



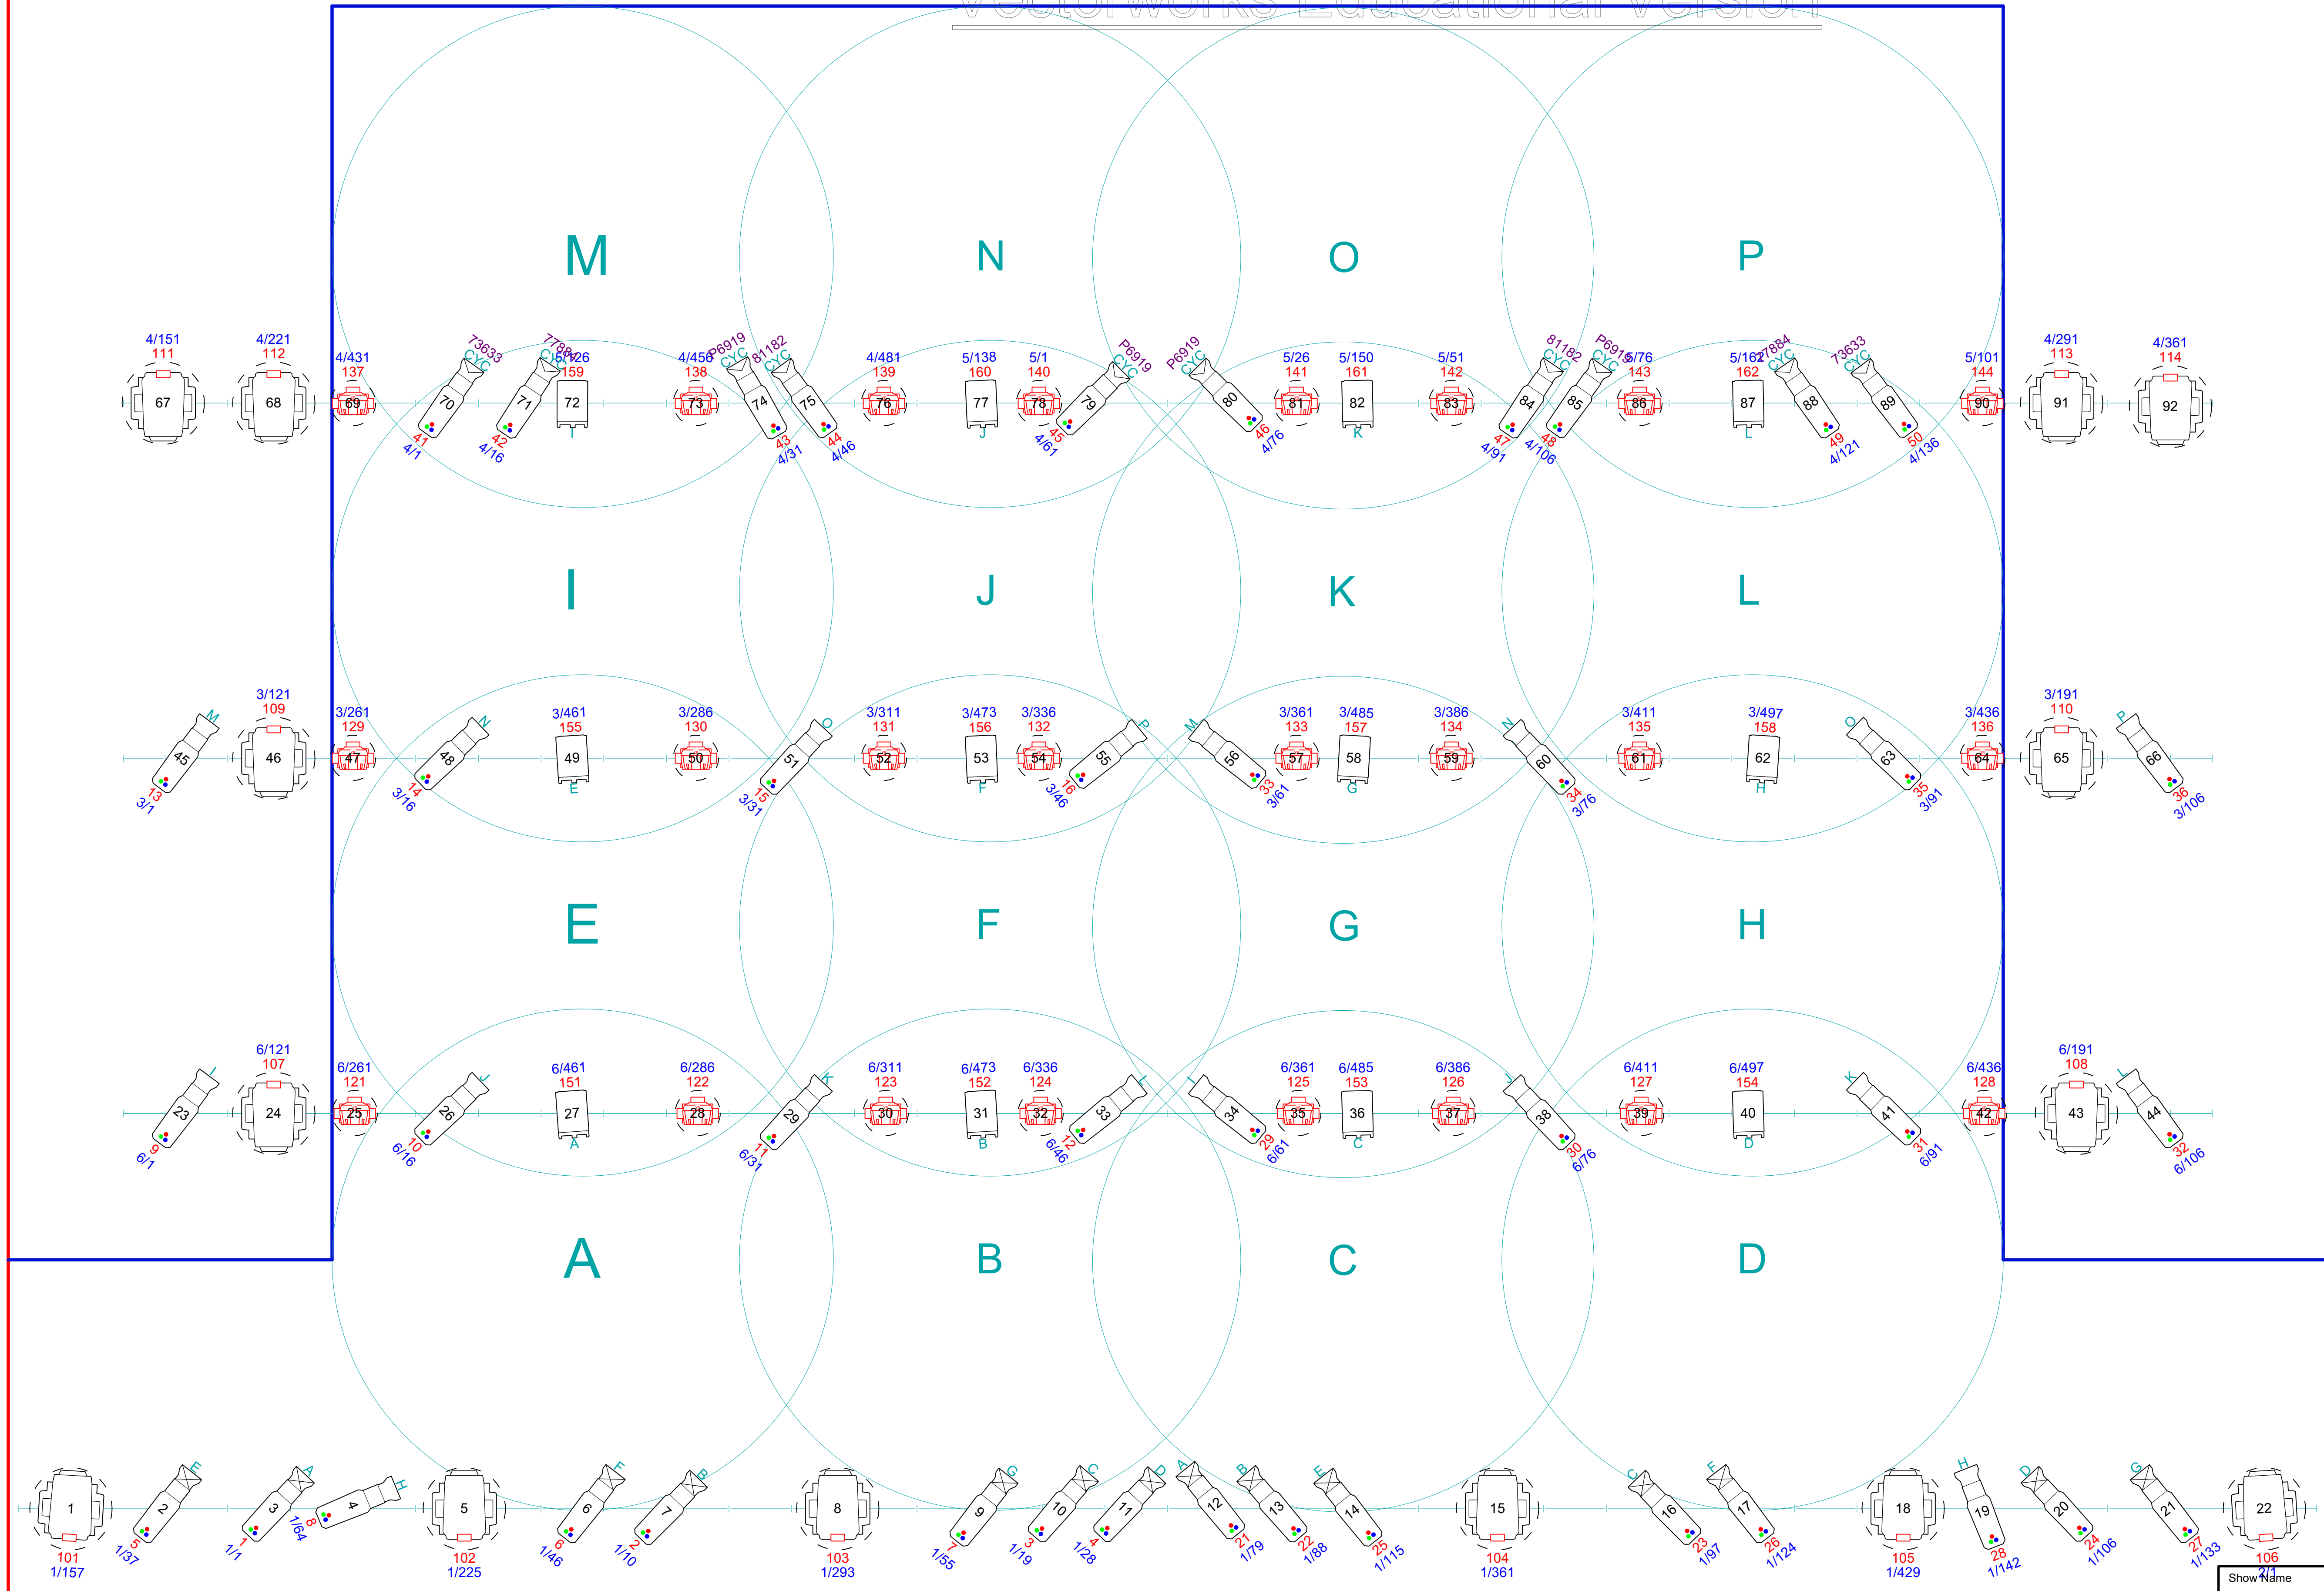

Instrument Key		
	ETC Source 4 LEDLS 36deg	19
	ETC Source 4 LEDLS 19deg	14
	Elation Proteus Lucius	14
	ETC Desire Fresnel USD	12
	Martin Mac Aura XB	24
	ETC Source 4 LEDLS 50deg	10

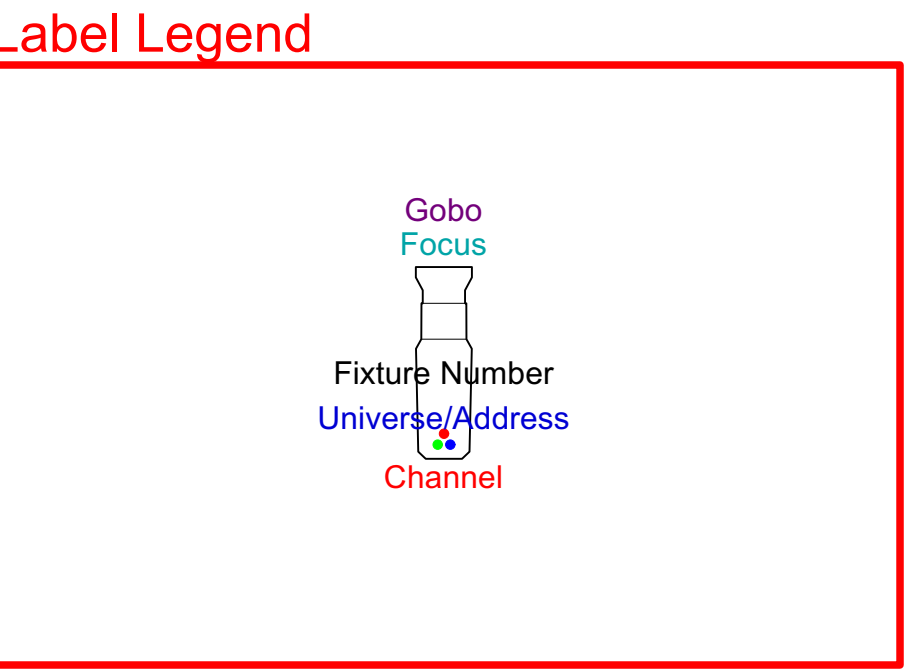

Show Name Winter Wonderland Strawberry Sun Lighting Plot		
Scale 1/2" = 1'	Drawn By Valentino Sanchez	Date 10/26/2023
CAD File Name Lighting plans for Winter Wonderland Strawberry Sun.vwx		